

APPROVED
By Tim Askin - Milwaukee HPC at 2:58 pm, Jun 26, 2023

In accordance with the provisions of Section 320-21 (11) and (12) of the Milwaukee Code of Ordinances, the Milwaukee Historic Preservation Commission has issued a certificate of appropriateness for the work listed on these pages. The work was found to be consistent with preservation guidelines. All work must be done in a craftsman-like manner, and must be completed within one year of the date this certificate was issued. Staff must approve any changes or additions to this certificate before work begins. Work that is not completed in accordance with this certificate may be subject to correction orders or citations.



GOLDA MEIR SCHOOL LOWER CAMPUS

VJS / MPS 176 - Golda Meir Lower Campus
1555 N Doctor M.L.K. Jr Drive, Milwaukee, WI 53212
MPS 176_Golda Meir_Lower Campus_Monument 1 (1)
Date: 06-26-23



4085 North 128th Street
Brookfield, WI 53005
p. 262-781-1500
www.LembergElectric.com

Monument Sign Specifications

One (1) Typical Monument Sign with New Sign Cabinet and Electronic Message Center (EMC) / New Masonry Base.

Illuminated / Double Sided / 21 Sq'

Main Sign Cabinet: Photocell for Automatic On & Off Lighting Control

(A) New Sign Cabinet

24" +/- deep fabricated aluminum sign cabinet with 1/8" routed aluminum faces, decorated with translucent vinyl graphics (and or digitally printed). Internal white LED illumination (Standard White).

(B) Electronic Message Center

Watchfire 16mm Full Color (RGB) LED Message Center. 2' x 5" viewable area. Note: Enclosure size is non-standard, to be custom fabricated. ACCESS PANEL IN TWO PARTS (2' H TOP / 6"H BOTTOM). TO ALLOW EMC SERVICE ONCE LB CONDUIT BODY IS INSTALLED - SEE NEXT SHEET

(C) Reveal

Fabricated aluminum reveal, 3"H x 68"W x 14"D

(D) Drip Cap

Fabricated aluminum brick cap with bent drip edge. To fit over existing masonry base (with holes to fit over existing poles) 6'- 3" x 2'-1" x 1.5"H.

(E) Masonry Base

Typical Masonry Base BY OTHER.

(F) Center Pole

4" x 4" x 1/4" steel center post, square / sign cabinet and EMC saddle mount post. Post is set in footing with masonry base constructed around it BY OTHER. Lemberg to coordinate setting of pole.

(G) Concrete Footing

6' 2" x 2' x 4' deep typical concrete footing / by other

(H) Antenna Location


4G Wireless with Watchfire Life of Sign Cellular Data Plan. Receiver shall be hidden and mounted on the inside of the sign enclosure, to reduce vandalism.

General Notes

All signage components: cabinet, retainers, reveal, and drip cap should be painted black. Sign to be oriented perpendicular from adjacent sidewalk and set back out of the public right of way, minimum setback TBD by city planner.

Colors:

- (1) Match PMS 300C Blue (MPS Logo)
- (2) Match PMS 129C Yellow (MPS Logo)
- (3) Match PMS Yellow C (Golda Meir Logo)
- (4) MP Black - Satin Finish
- (5) MP Purple - Satin Finish

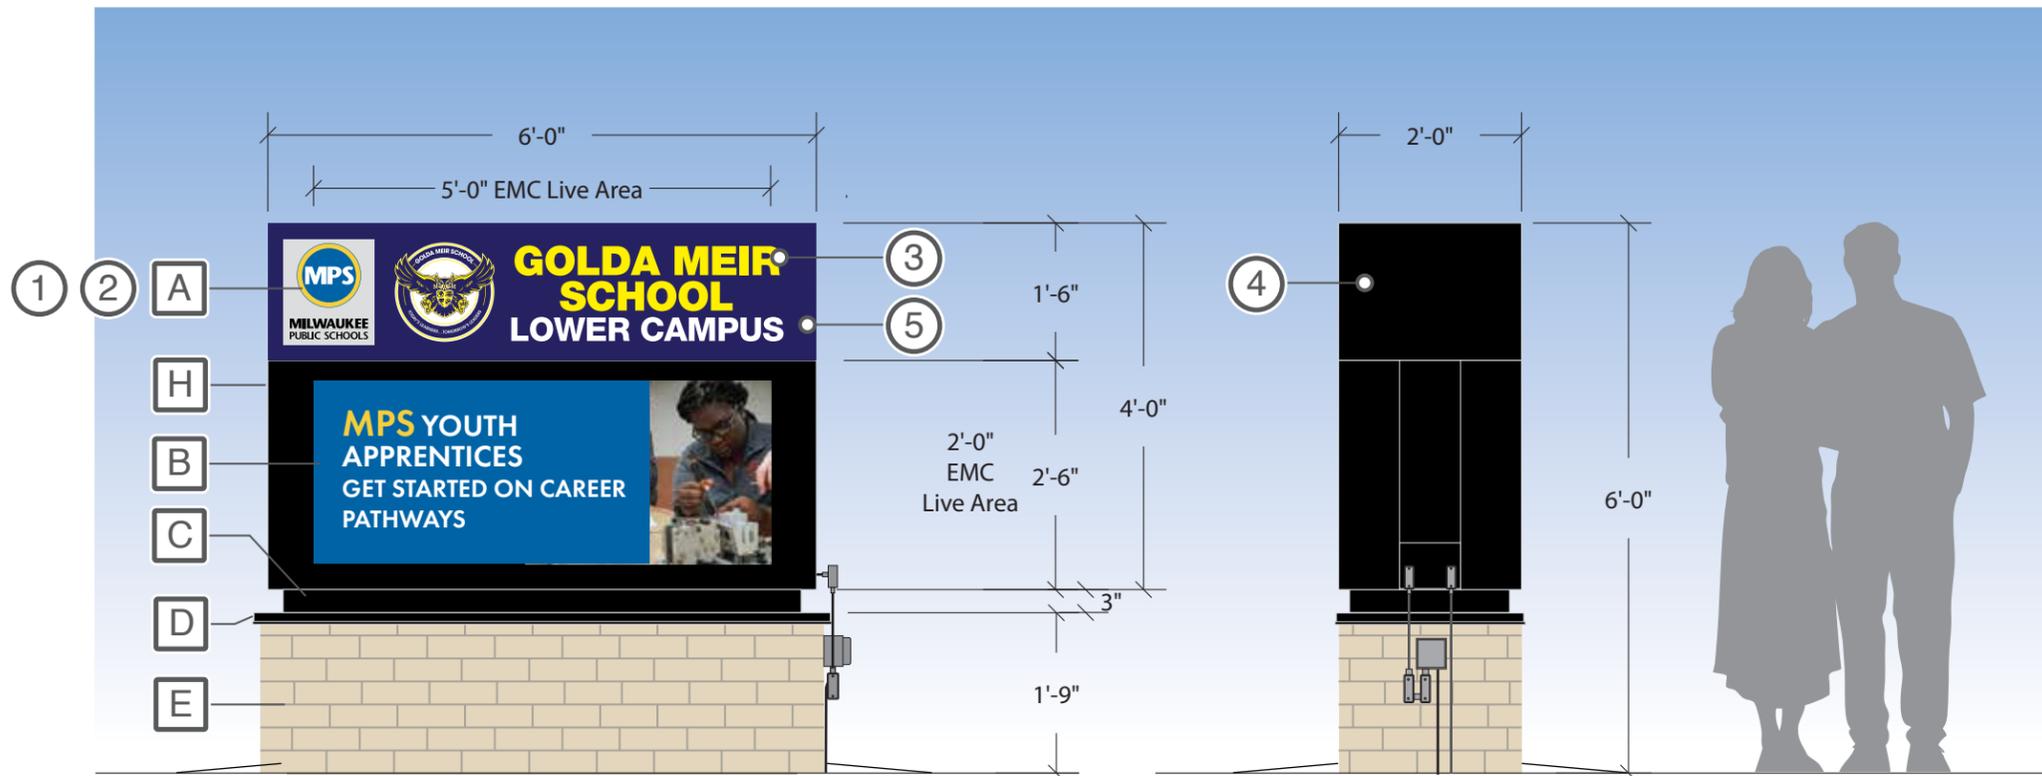


APPROVED
By Tim Askin - Milwaukee HPC at 2:58 pm, Jun 26, 2023



EXISTING VIEW - NTS



PROPOSED VIEW - NTS

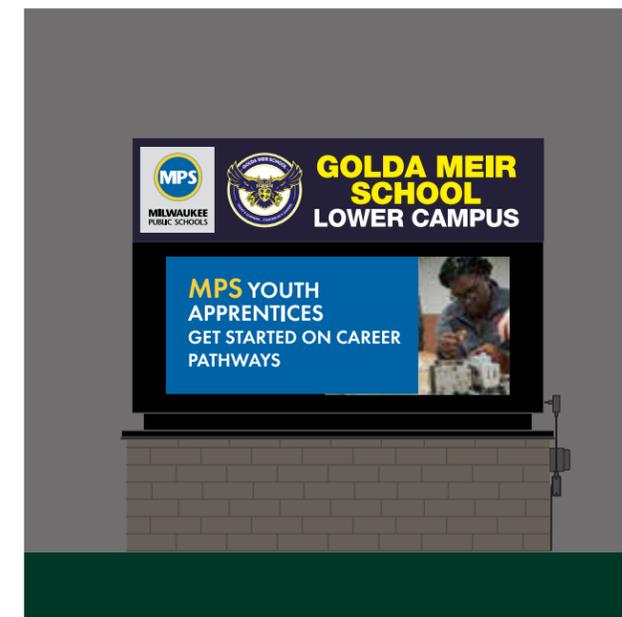

PROPOSED NIGHT VIEW - NTS

The sign shown in this photo rendering is approximate and may change pending a tech survey.



4085 North 128th Street
Brookfield, WI 53005
p. 262-781-1500
www.LembergElectric.com

Client: VJS / MPS 176 - Golda Meir Lower Campus

Location: 1555 N Doctor M.L.K. Jr Drive

City: Milwaukee, WI

Sales Representative: Brian Pritzkow

Project Manager: Zane Nichols

Designer: Eric Bailey / ALS / Mark Mayzik

Scale: 1/2"=1'

Paper Size: 11x17

Signature / Date:

Client / Location or Project / Sign Classification / Version# or Sheet / Revision# / Drawing Status

MPS_Golda Meir_MON(OV)_v01_r01_D

Date:

06-26-23

Monument Sign Specifications

One (1) Typical Monument Sign with New Sign Cabinet and Electronic Message Center (EMC) / New Masonry Base.

Illuminated / Double Sided / 21 Sq'

Main Sign Cabinet: Photocell for Automatic On & Off Lighting Control

(A) New Sign Cabinet

24" +/- deep fabricated aluminum sign cabinet with 1/8" routed aluminum faces, decorated with translucent vinyl graphics (and or digitally printed). Internal white LED illumination (Standard White).

(B) Electronic Message Center

Watchfire 16mm Full Color (RBG) LED Message Center. 2' x 5" viewable area. Note: Enclosure size is non-standard, to be custom fabricated. ACCESS PANEL IN TWO PARTS (2' H TOP / 6" H BOTTOM). TO ALLOW EMC SERVICE ONCE LB CONDUIT BODY IS INSTALLED

(C) Reveal

Fabricated aluminum reveal, 3"H x 68"W x 14"D

(D) Drip Cap

Fabricated aluminum brick cap with bent drip edge. To fit over existing masonry base (with holes to fit over existing poles) 6'-3" x 2'-1" x 1.5"H.

(E) Masonry Base

Typical Masonry Base BY OTHER.

(F) Center Pole

4" x 4" x 1/4" steel center pole, square / sign cabinet and EMC saddle mount pole. Pole is set in footing with masonry base constructed around it BY OTHER. Lemberg to coordinate setting of pole.

(G) Concrete Footing


6' 2" x 2' x 4' deep typical concrete footing / by other

(H) Antenna Location

4G Wireless with Watchfire Life of Sign Cellular Data Plan. Receiver shall be hidden and mounted on the inside of the sign enclosure, to reduce vandalism.

General Notes

All signage componets: cabinet, retainers, reveal, and drip cap should be painted black. Sign to be oriented perpendicular from adjacent sidewalk and set back out of the public right of way, minimum setback TBD by city planner.

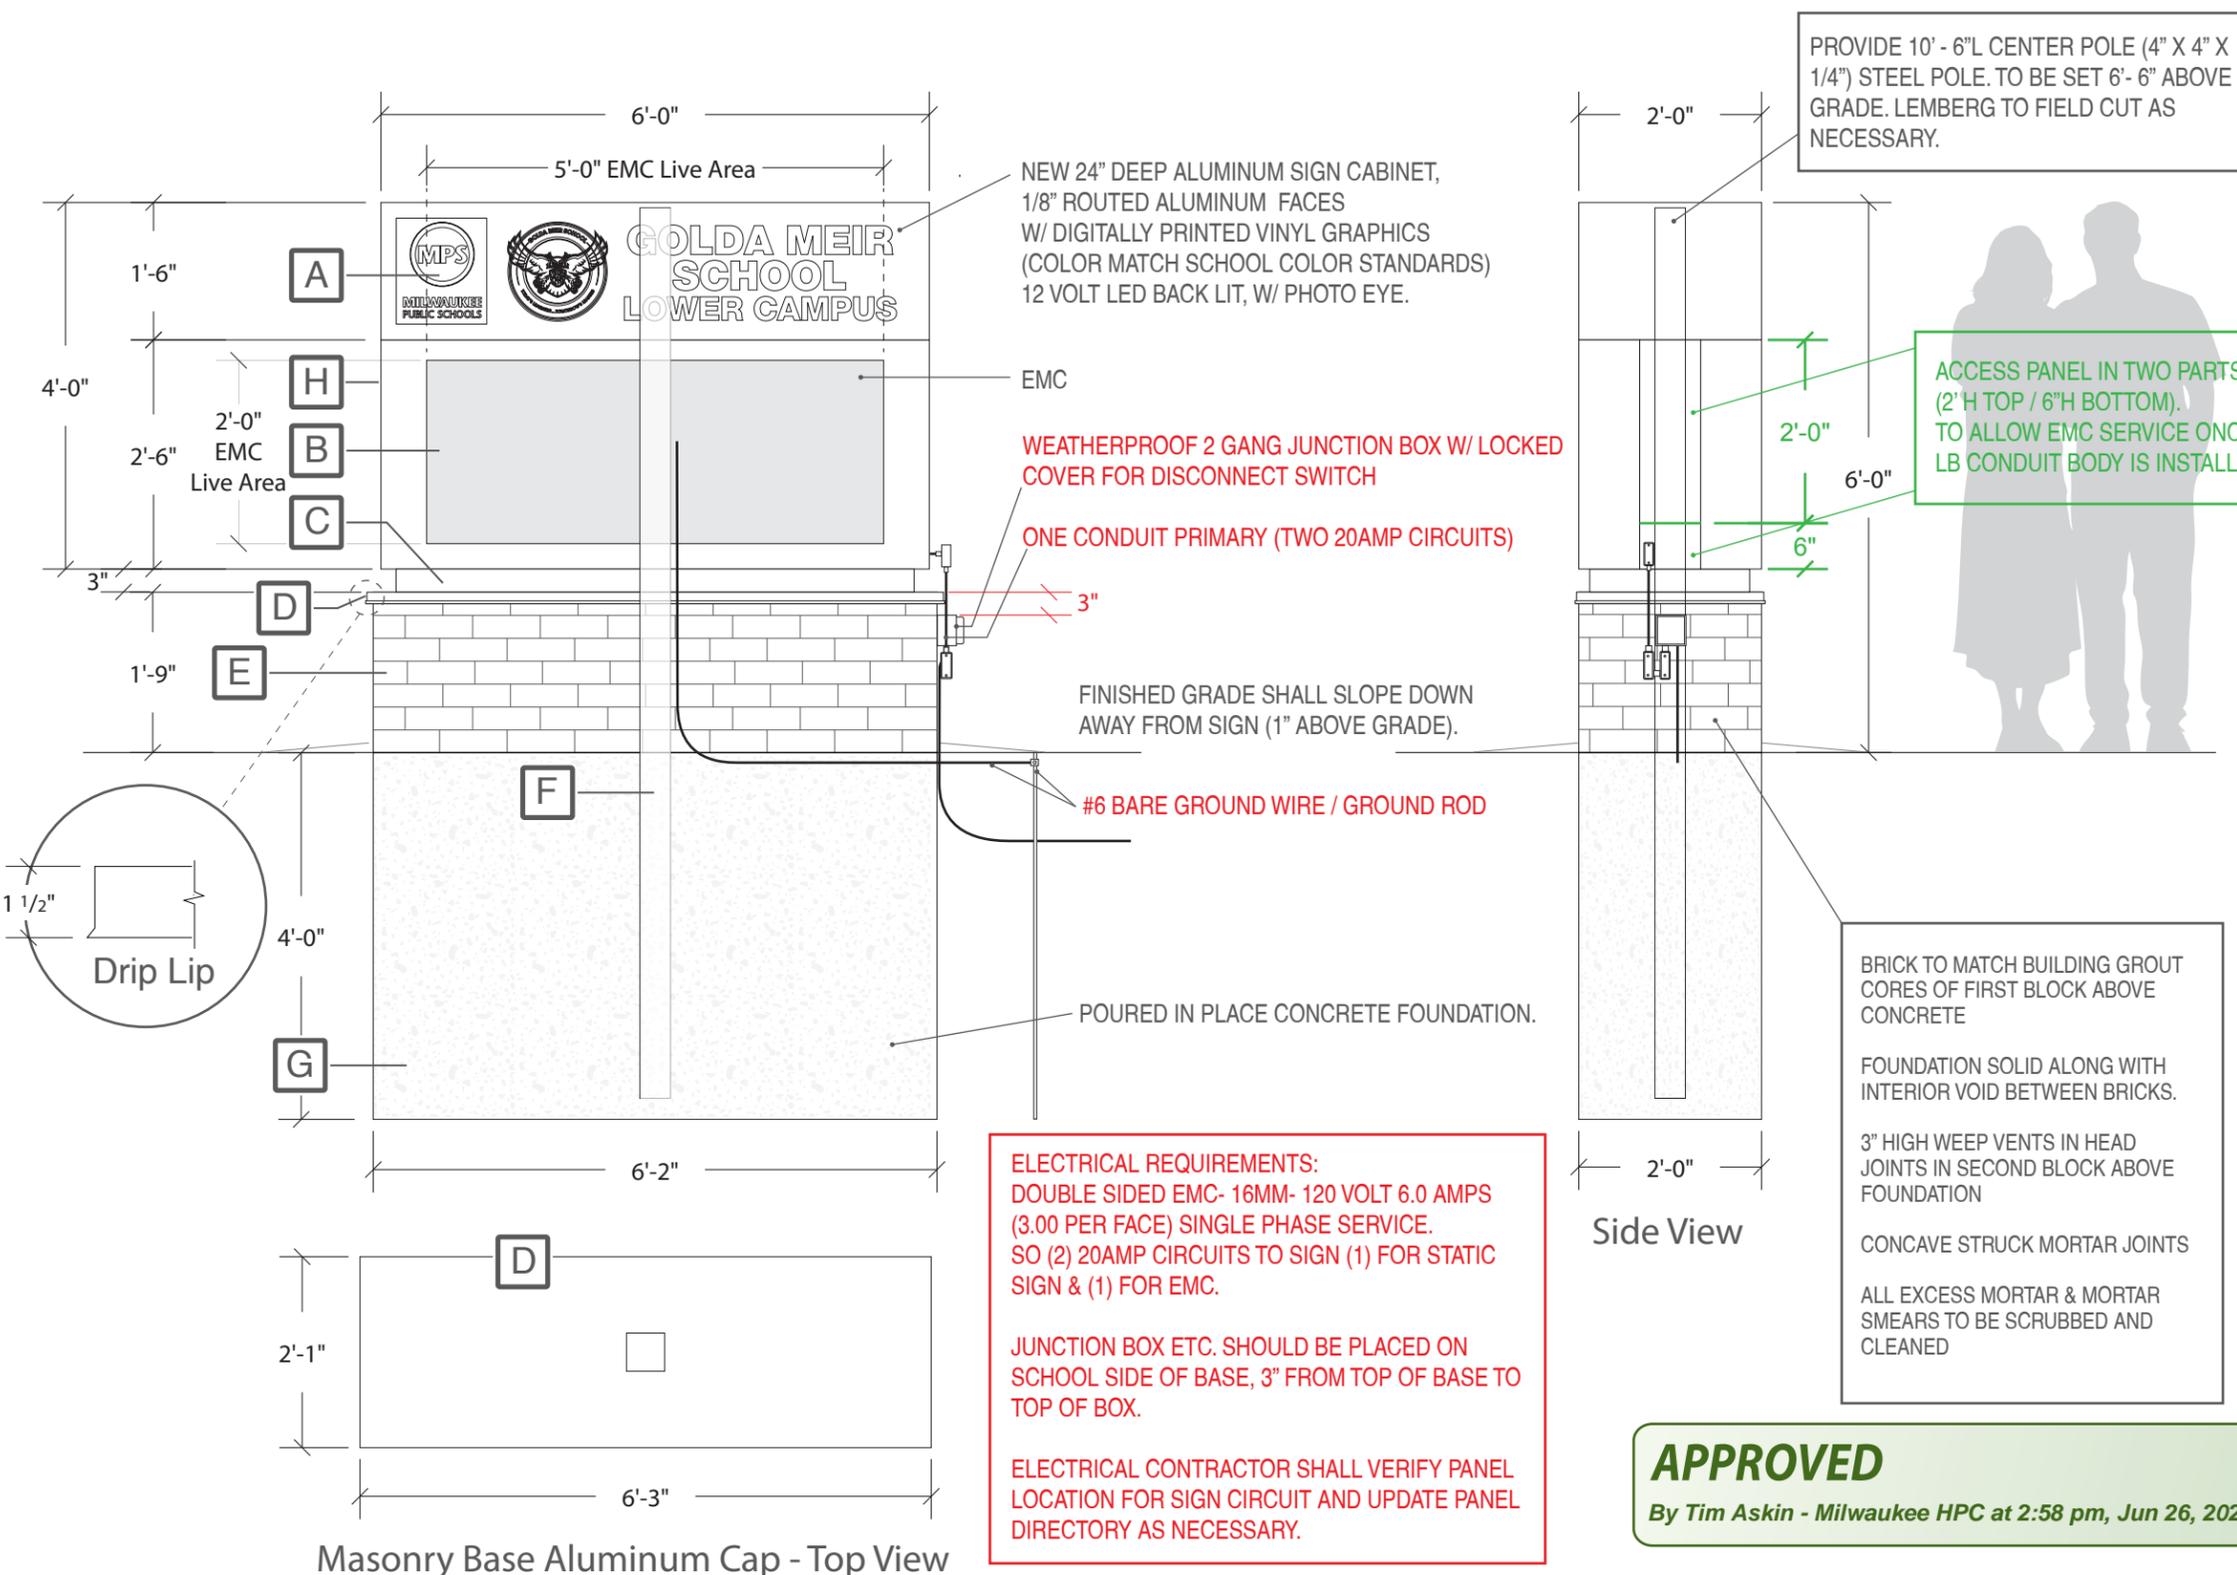

APPROVED
 By Tim Askin - Milwaukee HPC at 2:58 pm, Jun 26, 2023



SIGNS

4085 North 128th Street
 Brookfield, WI 53005
 p. 262-781-1500
 www.LembergElectric.com

Client: VJS / MPS 176 - Golda Meir Lower Campus

Location: 1555 N Doctor M.L.K. Jr Drive

City: Milwaukee, WI

Sales Representative: Brian Pritzkow

Project Manager: Zane Nichols

Designer: Eric Bailey / ALS / Mark Mayzik

Scale: 1/2"=1'

Paper Size: 11x17

Signature / Date:

Client / Location or Project / Sign Classification / Version# or Sheet / Revision# / Drawing Status

MPS_Golda Meir_MON(DD)_v01_r01_D

Date:

06-26-23



APPROVED
By Tim Askin - Milwaukee HPC at 2:58 pm, Jun 26, 2023



SIGNS

4085 North 128th Street
Brookfield, WI 53005
p. 262-781-1500
www.LembergElectric.com

Client: VJS / MPS 176 - Golda Meir Lower Campus

Location: 1555 N Doctor M.L.K. Jr Drive

City: Milwaukee, WI

Sales Representative: Brian Pritzkow

Project Manager: Zane Nichols

Designer: Eric Bailey / ALS

Scale: N/A

Paper Size: 11x17

Signature / Date:

Client / Location or Project / Sign Classification / Version# or Sheet / Revision# / Drawing Status

MPS_Golda Meir_SURVEY_v01_r00_D


Date:

03-31-23

Exterior Digital Monument Sign - New

APPROVED

By Tim Askin - Milwaukee HPC at 2:58 pm, Jun 26, 2023

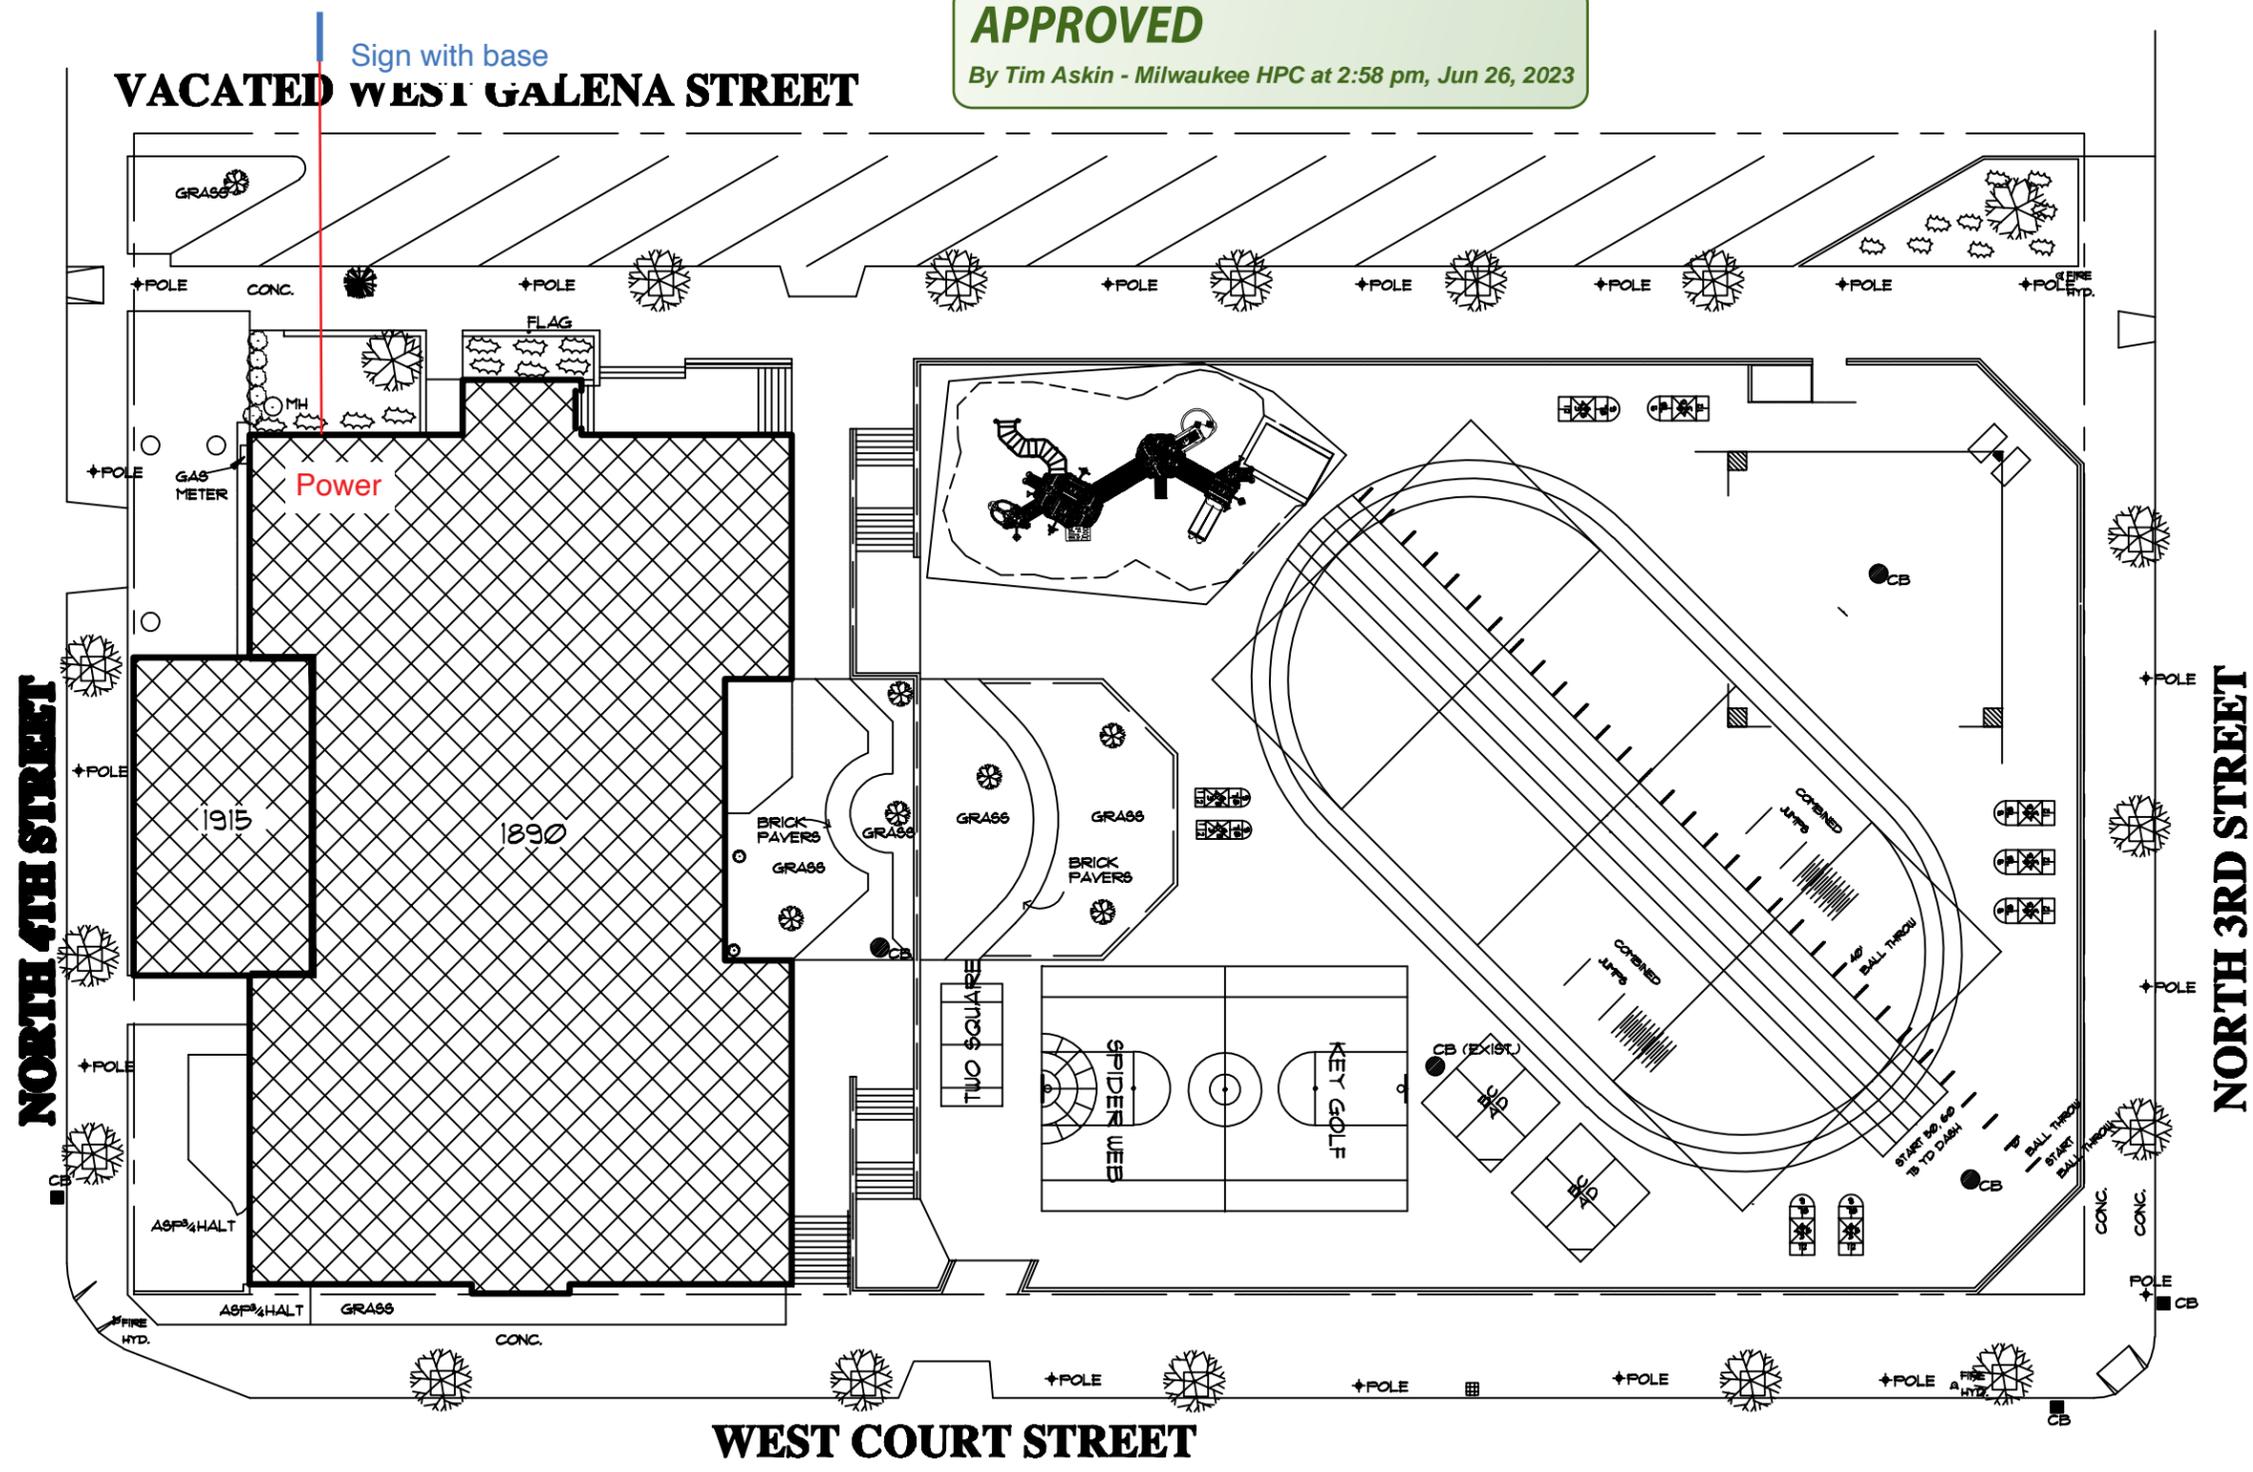

4085 North 128th Street
 Brookfield, WI 53005
 p. 262-781-1500
 www.LembergElectric.com

Client: VJS / MPS 176 - Golda Meir Lower Campus
 Location: 1555 N Doctor M.L.K. Jr Drive
 City: Milwaukee, WI

Sales Representative: Brian Pritzkow
 Project Manager: Zane Nichols
 Designer: Eric Bailey / ALS

Scale: N/A
 Paper Size: 11x17
 Signature / Date:

Client / Location or Project / Sign Classification / Version# or Sheet / Revision# / Drawing Status Date:
 MPS_Golda Meir_MAP_v01_r00_D 03-31-23

Notes & Revisions | Check List & Flagged Items

03-31-23
Initial drawing.
ALS

-

06-26-23
Changed monument sign polycarbonate face to routed aluminum.
MCM

-



-

-

APPROVED
By Tim Askin - Milwaukee HPC at 2:58 pm, Jun 26, 2023

-

-

Job File Location Sales:Customer Folders/_/_/_/_/Art Work | Job File Location Design:Sign Vault_20/_/_/_



SIGNS

4085 North 128th Street
Brookfield, WI 53005
p. 262-781-1500
www.LembergElectric.com

Client: VJS / MPS 176 - Golda Meir Lower Campus

Sales Representative: Brian Pritzkow

Scale: N/A

Client / Location or Project / Sign Classification / Version# or Sheet / Revision# / Drawing Status

MPS_Golda Meir_PN_v01_r01_D

Date:

06-26-23

Location: 1555 N Doctor M.L.K. Jr Drive

Project Manager: Zane Nichols

Paper Size: 11x17

City: Milwaukee, WI

Designer: Eric Bailey / ALS / Mark Mayzik

Signature / Date:

These designs are the exclusive property of Lemberg Electric Inc. Use or duplication without expressed written permission of Lemberg Electric Inc. Is prohibited. Drawings are for conceptual use only. The document represents an approximation of materials & colors. Actual product colors may vary.